



8 7 6 5 4 3 2 1

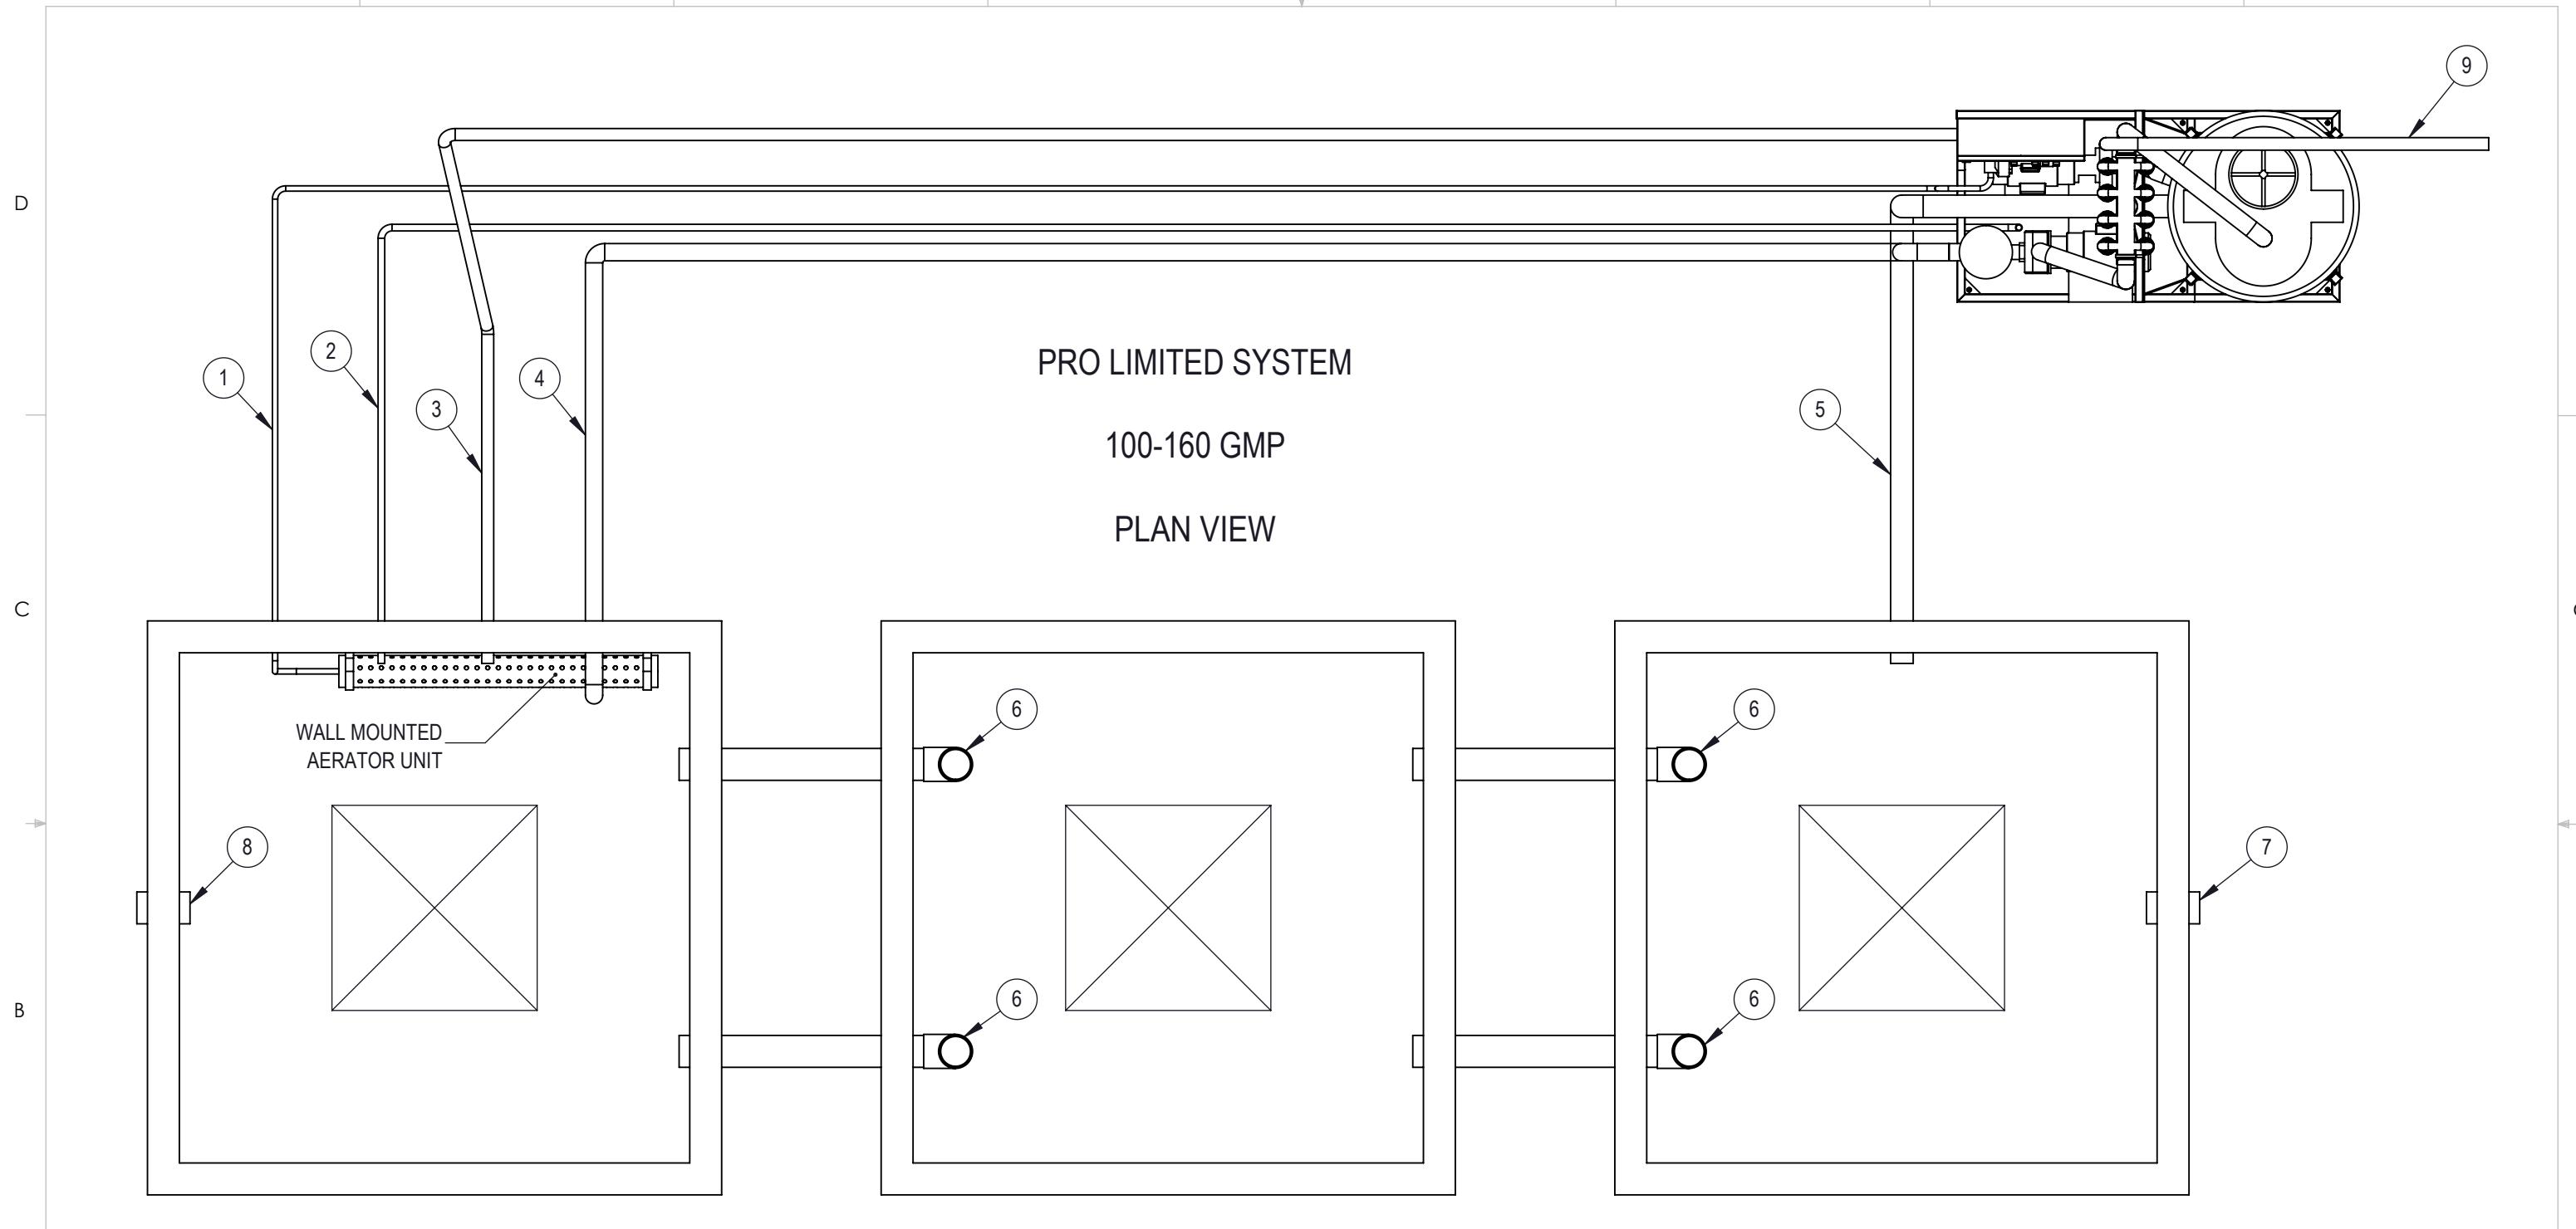


PIPE INFO	
1	1" AIR PIPE
2	1" WATER PIPE
3	2" ELECTRICAL CONDUIT
4	3" SUCTION PIPE
5	4" CYCLONE RETURN PIPE
6	6" DOWNTURN PIPE
7	6" PIPE FROM CAR WASH
8	6" PIPE TO SEWER
9	2" PIPE TO CAR WASH

AQUA BIO Technologies		
SIZE	DWG. NO.	REV
B	PLS-001	
SCALE: 1:30	WEIGHT:	SHEET 1 OF 5
UNLESS OTHERWISE SPECIFIED:	NAME	DATE
DIMENSIONS ARE IN INCHES	GM	5/1/2016
TOLERANCES:		
FRACTIONAL $\pm$		
ANGULAR: MACH $\pm$		
BEND $\pm$		
TWO PLACE DECIMAL $\pm$		
THREE PLACE DECIMAL $\pm$		
CAD DESIGN BY:		
CADWorksPro		
Chicago, IL		
gilm@cadworkspro.com		
PROPRIETARY AND CONFIDENTIAL	MATERIAL	
THE INFORMATION CONTAINED IN THIS DRAWING		
IS THE SOLE PROPERTY OF		
AQUA BIO Technologies.		
ANY REPRODUCTION IN PART OR AS A WHOLE		
WITHOUT THE WRITTEN PERMISSION OF		
AQUA BIO Technologies		
IS PROHIBITED.		
DO NOT SCALE DRAWING		

8 7 6 5 4 3 2 1

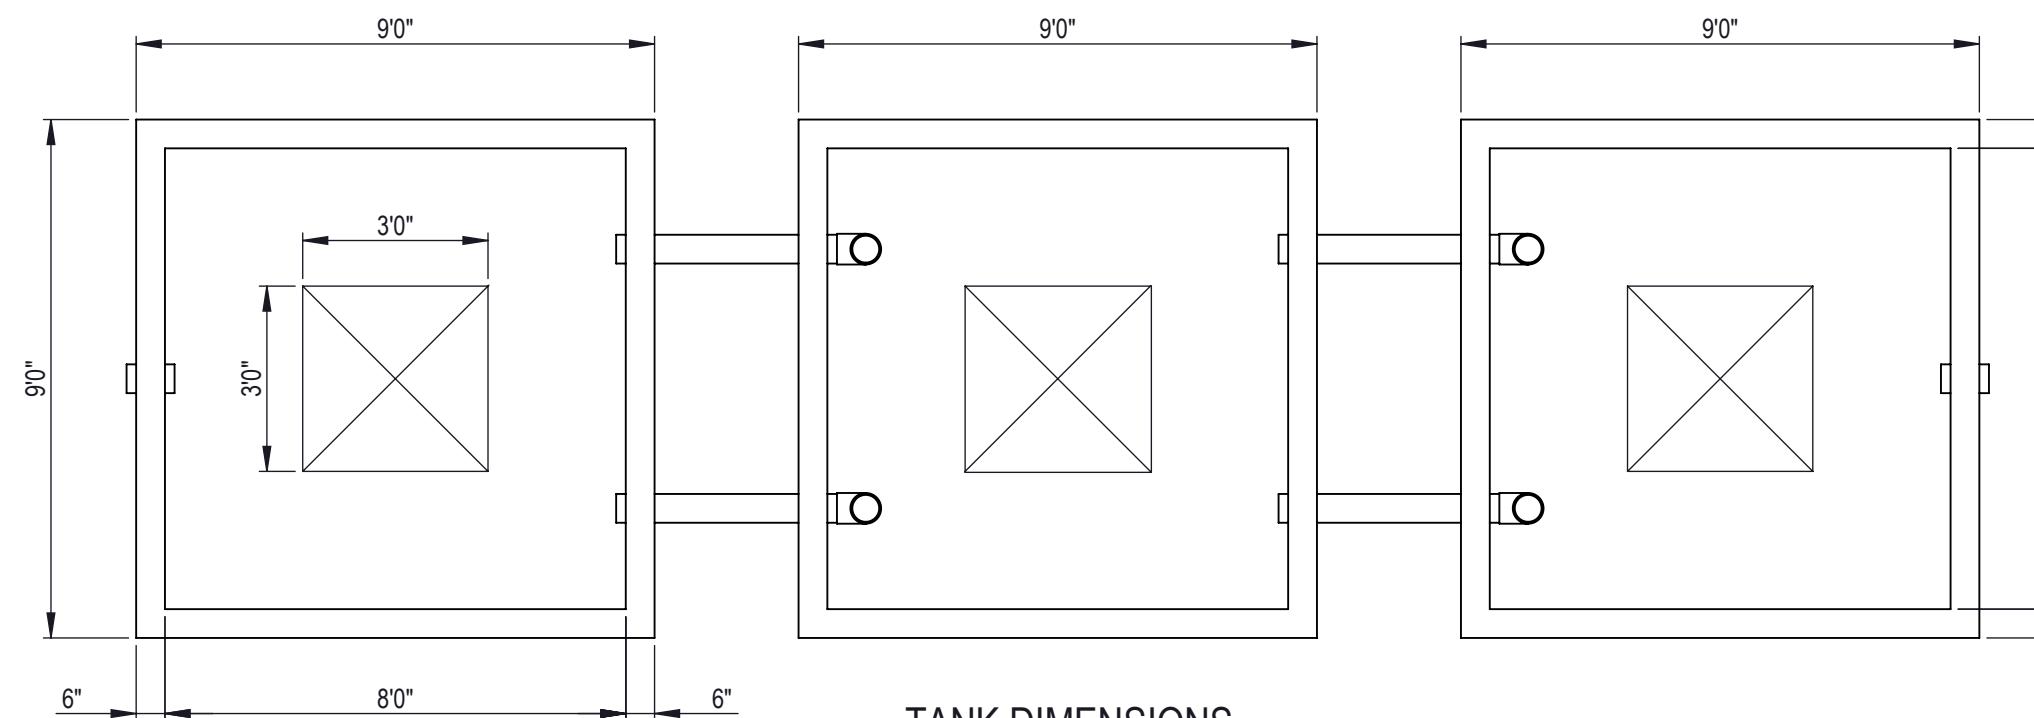

TANK DIMENSIONS  
TOP VIEW

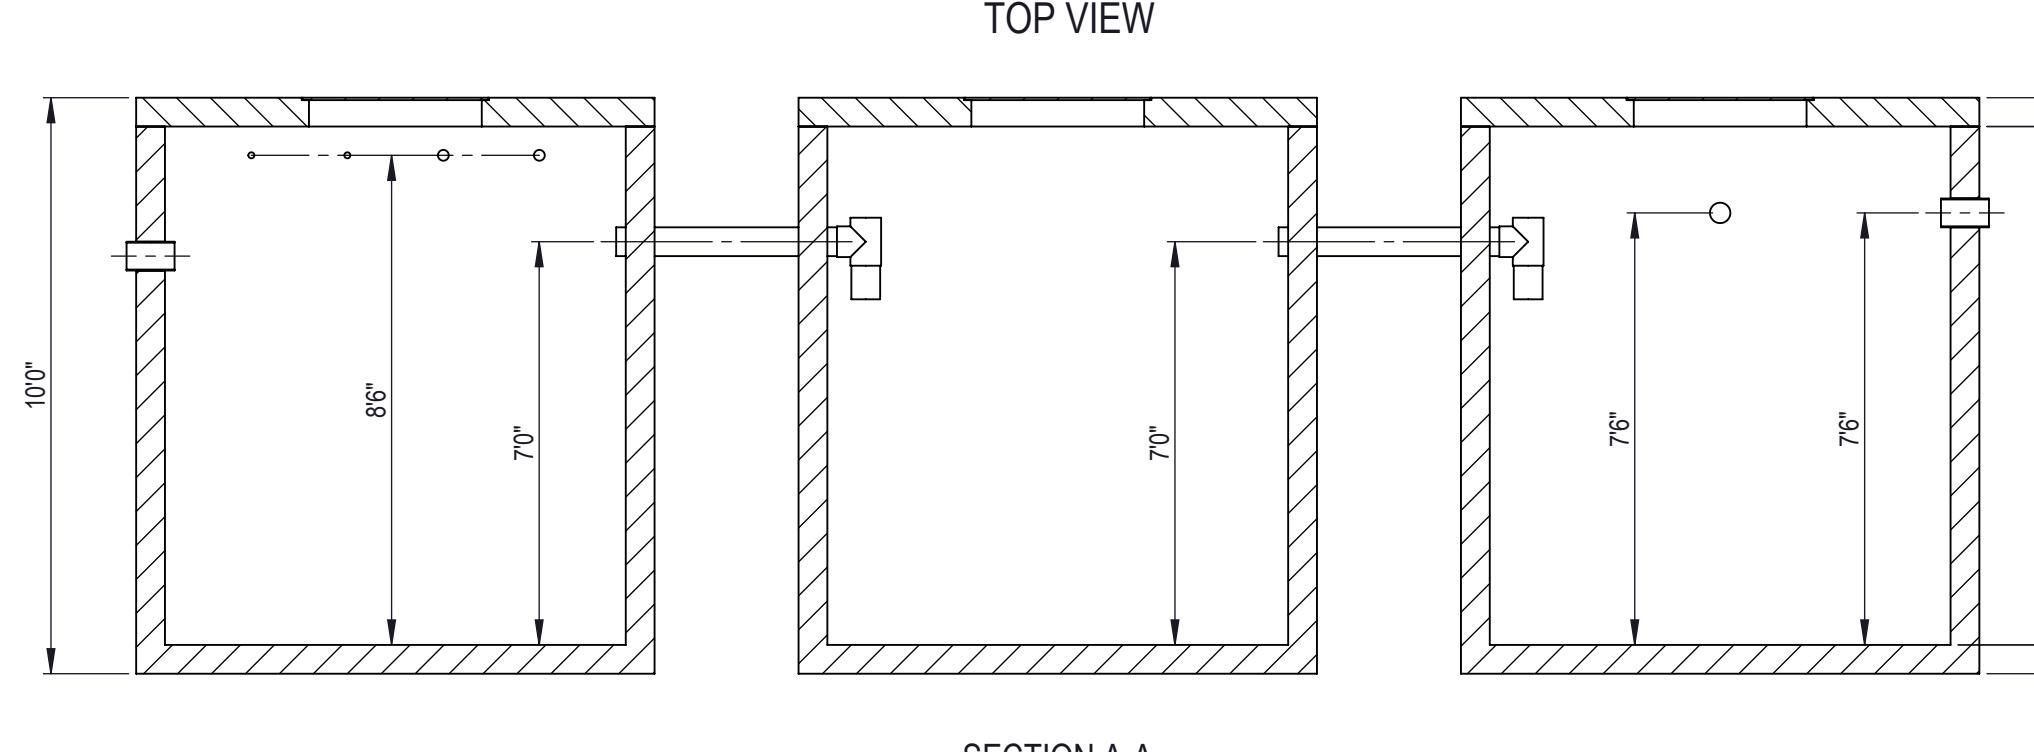

SECTION A-A

TANK AND PIPING DIMENSIONS  
SIDE VIEW

PROPRIETARY AND CONFIDENTIAL  
THE INFORMATION CONTAINED IN THIS DRAWING  
IS THE SOLE PROPERTY OF  
AQUA BIO Technologies.  
ANY REPRODUCTION IN PART OR AS A WHOLE  
WITHOUT THE WRITTEN PERMISSION OF  
AQUA BIO Technologies  
IS PROHIBITED.

UNLESS OTHERWISE SPECIFIED:	NAME	DATE
DIMENSIONS ARE IN INCHES	DRAWN	GM
TOLERANCES: FRACTIONAL $\pm$ ANGULAR: MACH $\pm$ BEND $\pm$	CHECKED	
TWO PLACE DECIMAL $\pm$ THREE PLACE DECIMAL $\pm$	APPROVED	
CAD DESIGN BY:		
CADWorksPro Chicago, IL		
gilm@cadworkspro.com		

**AQUA BIO Technologies**

TITLE: Pro Limited System - 100-160 GPM

Tank and Piping Dimensions

SIZE DWG. NO. REV

**B** PLS-002

SCALE: 1:40 WEIGHT: SHEET 2 OF 5

8 7 6 5 4 3 2 1

A


D

C

B

A

1

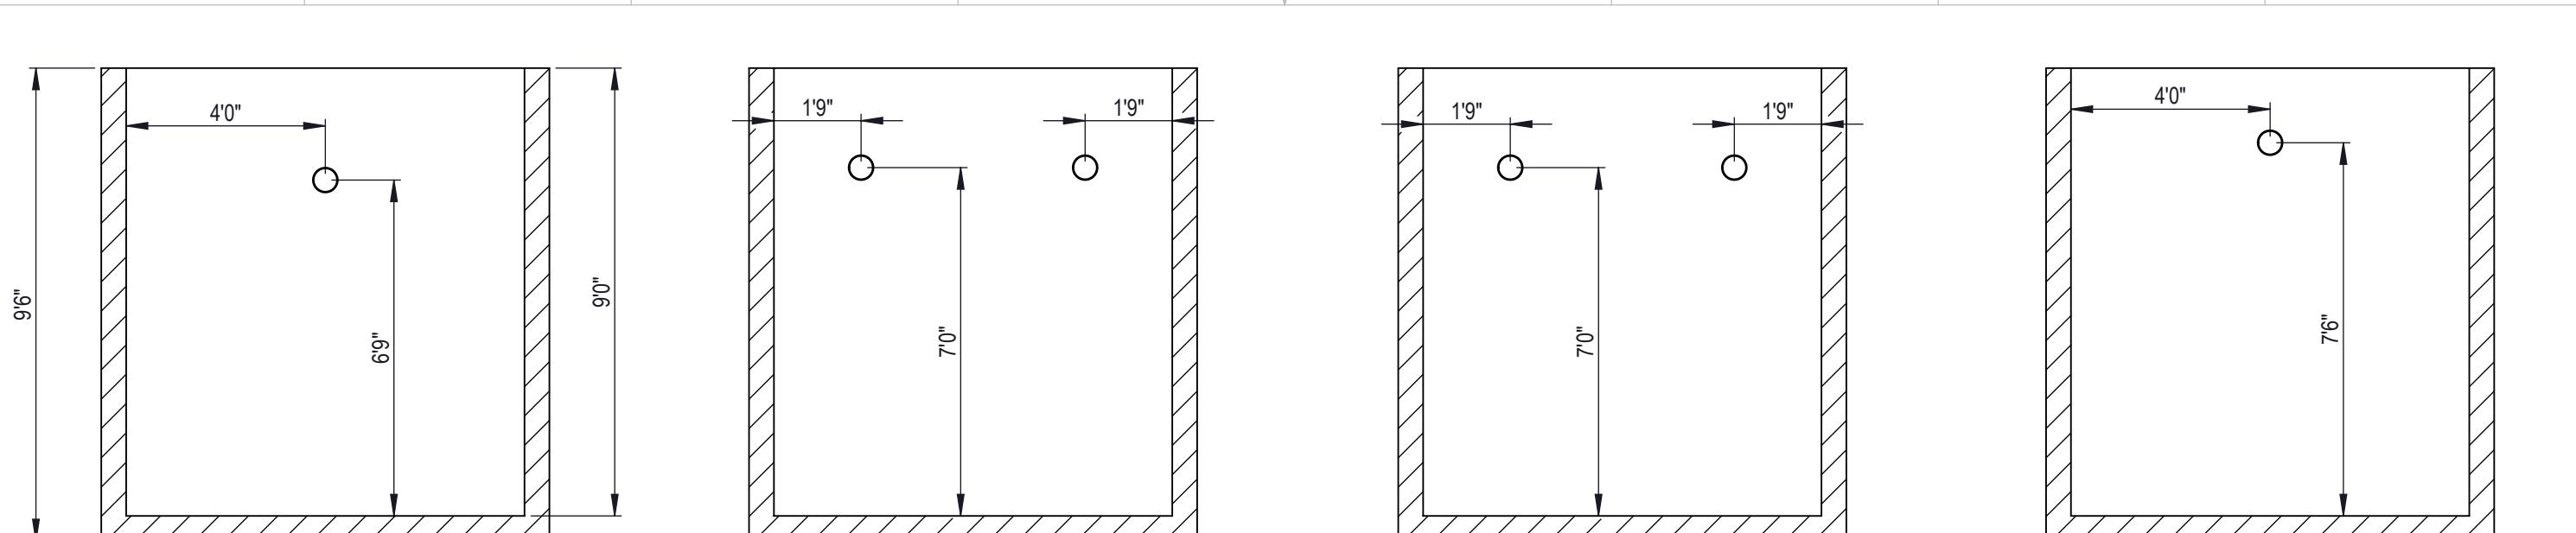


SECTION D-D

SECTION C-C

SECTION B-B

SECTION A-A

**TANK PIPE LOCATION  
WALL SECTIONS**

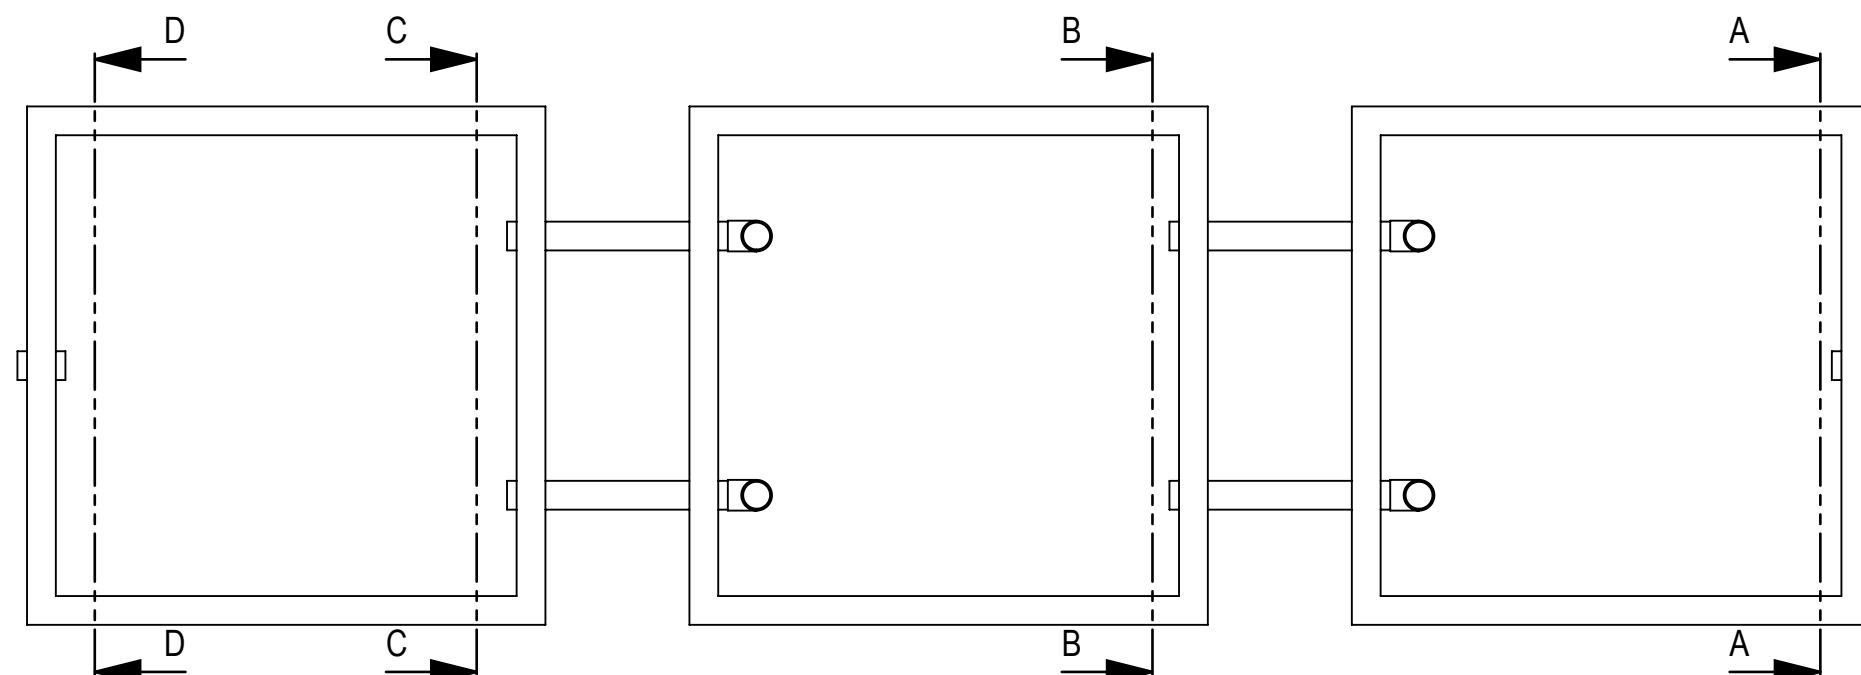

**TANKS TOP VIEW  
TANK TOP NOT SHOWN**


PROPRIETARY AND CONFIDENTIAL  
THE INFORMATION CONTAINED IN THIS DRAWING  
IS THE SOLE PROPERTY OF  
AQUA BIO Technologies.  
ANY REPRODUCTION IN PART OR AS A WHOLE  
WITHOUT THE WRITTEN PERMISSION OF  
AQUA BIO Technologies  
IS PROHIBITED.

UNLESS OTHERWISE SPECIFIED:	NAME	DATE
DIMENSIONS ARE IN INCHES	DRAWN	GM
TOLERANCES: FRACTIONAL $\pm$ ANGULAR: MACH $\pm$ BEND $\pm$	CHECKED	
TWO PLACE DECIMAL $\pm$ THREE PLACE DECIMAL $\pm$	APPROVED	
CAD DESIGN BY:		
	CADWorksPro	
	Chicago, IL	
	gilm@cadworkspro.com	




**AQUA BIO Technologies**

**TITLE:**  
**Pro Limited System - 100-160 GPM**  
**Tank Wall Sections**

SIZE	DWG. NO.	REV
<b>B</b>	<b>PLS-003</b>	
SCALE: 1:40	WEIGHT:	SHEET 3 OF 5

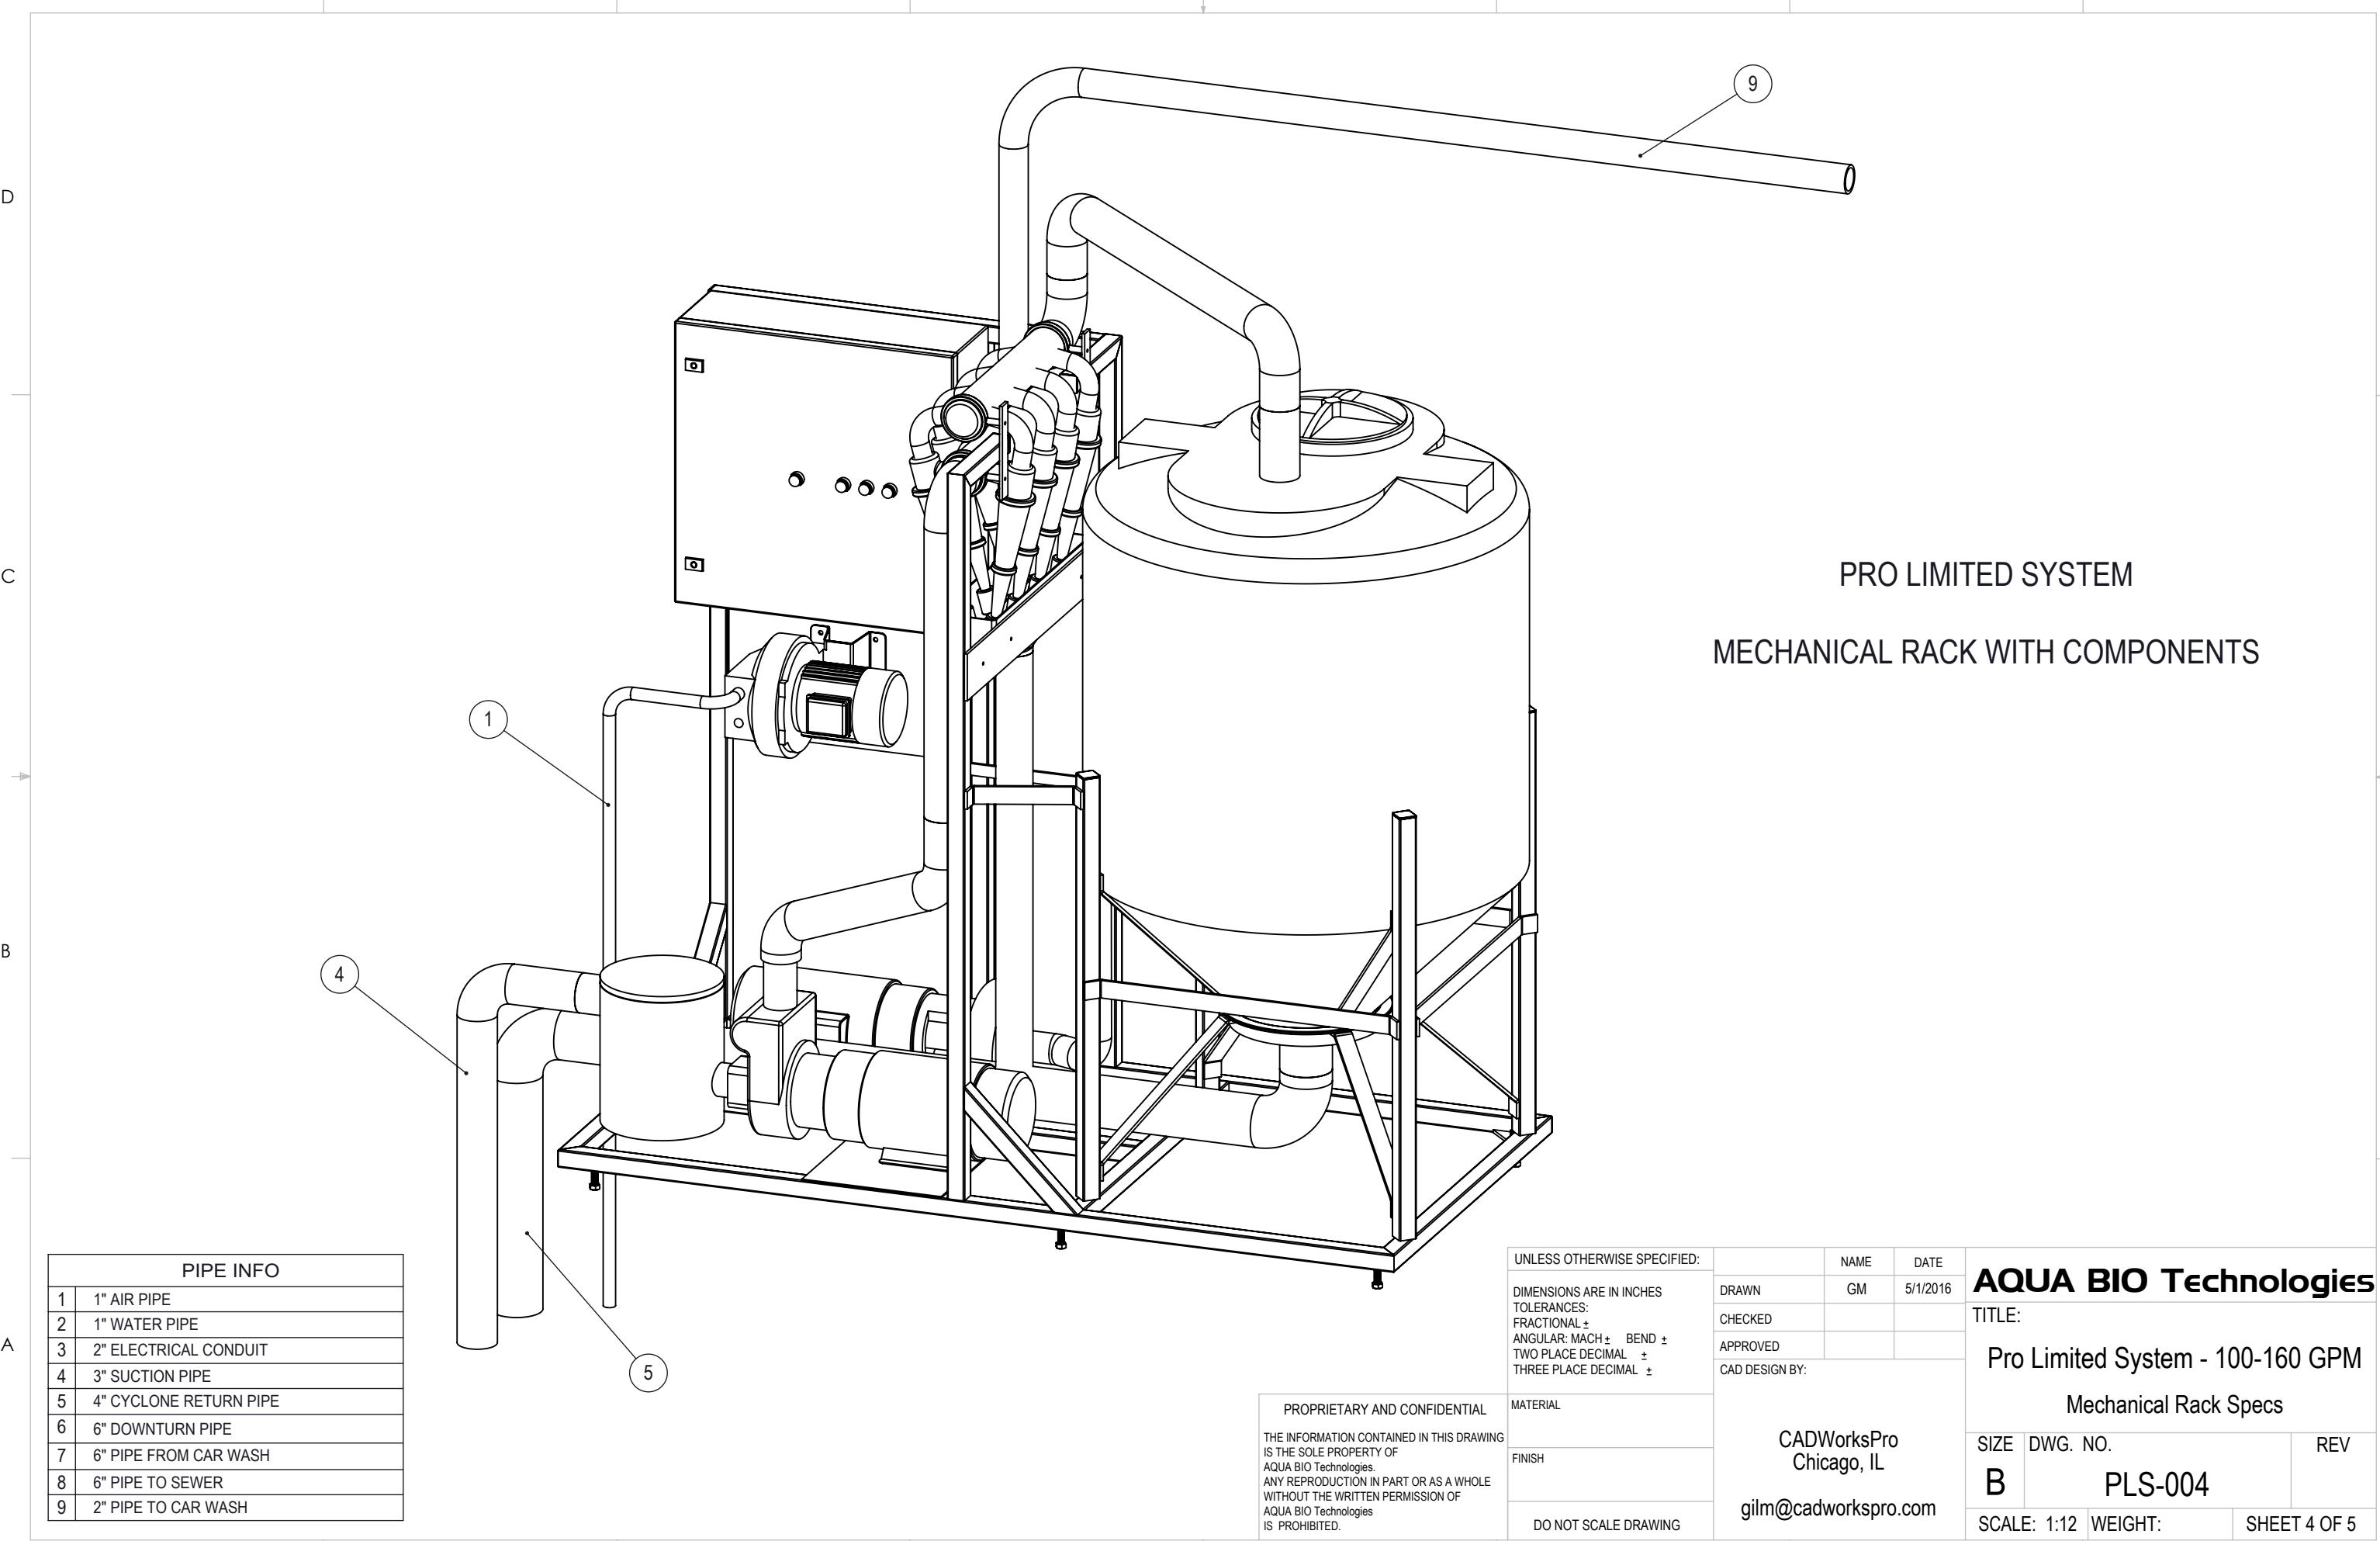

8 7 6 5 4 3 2 1

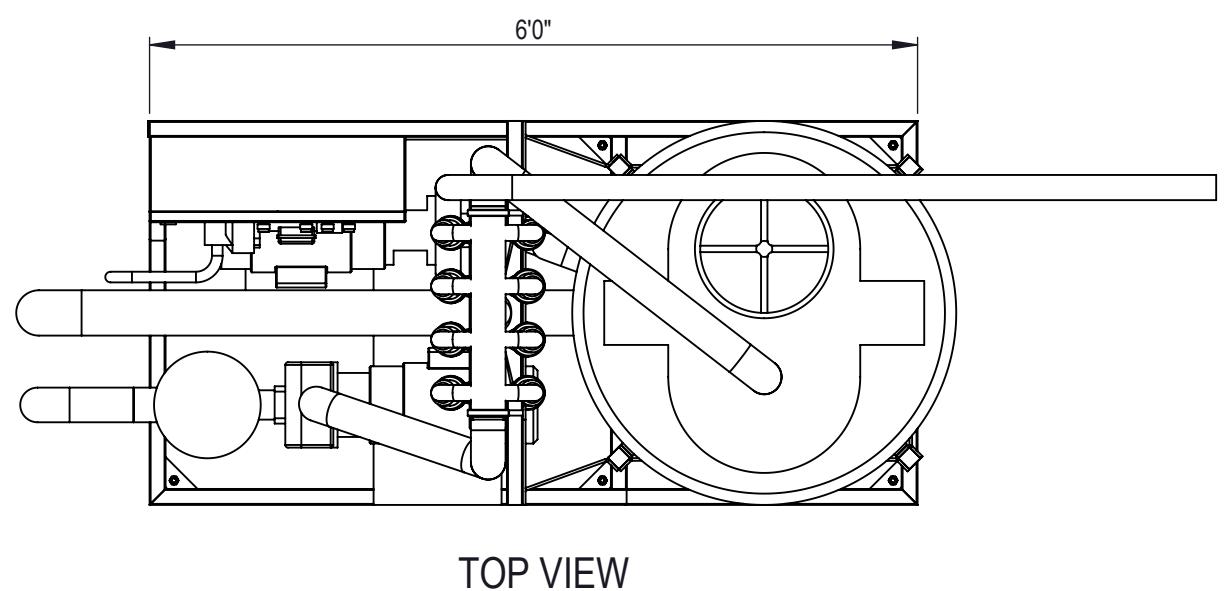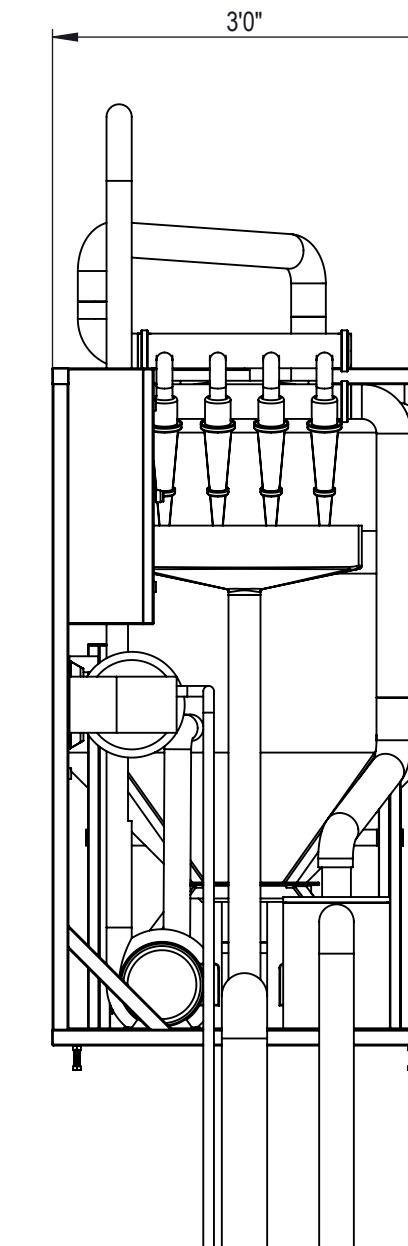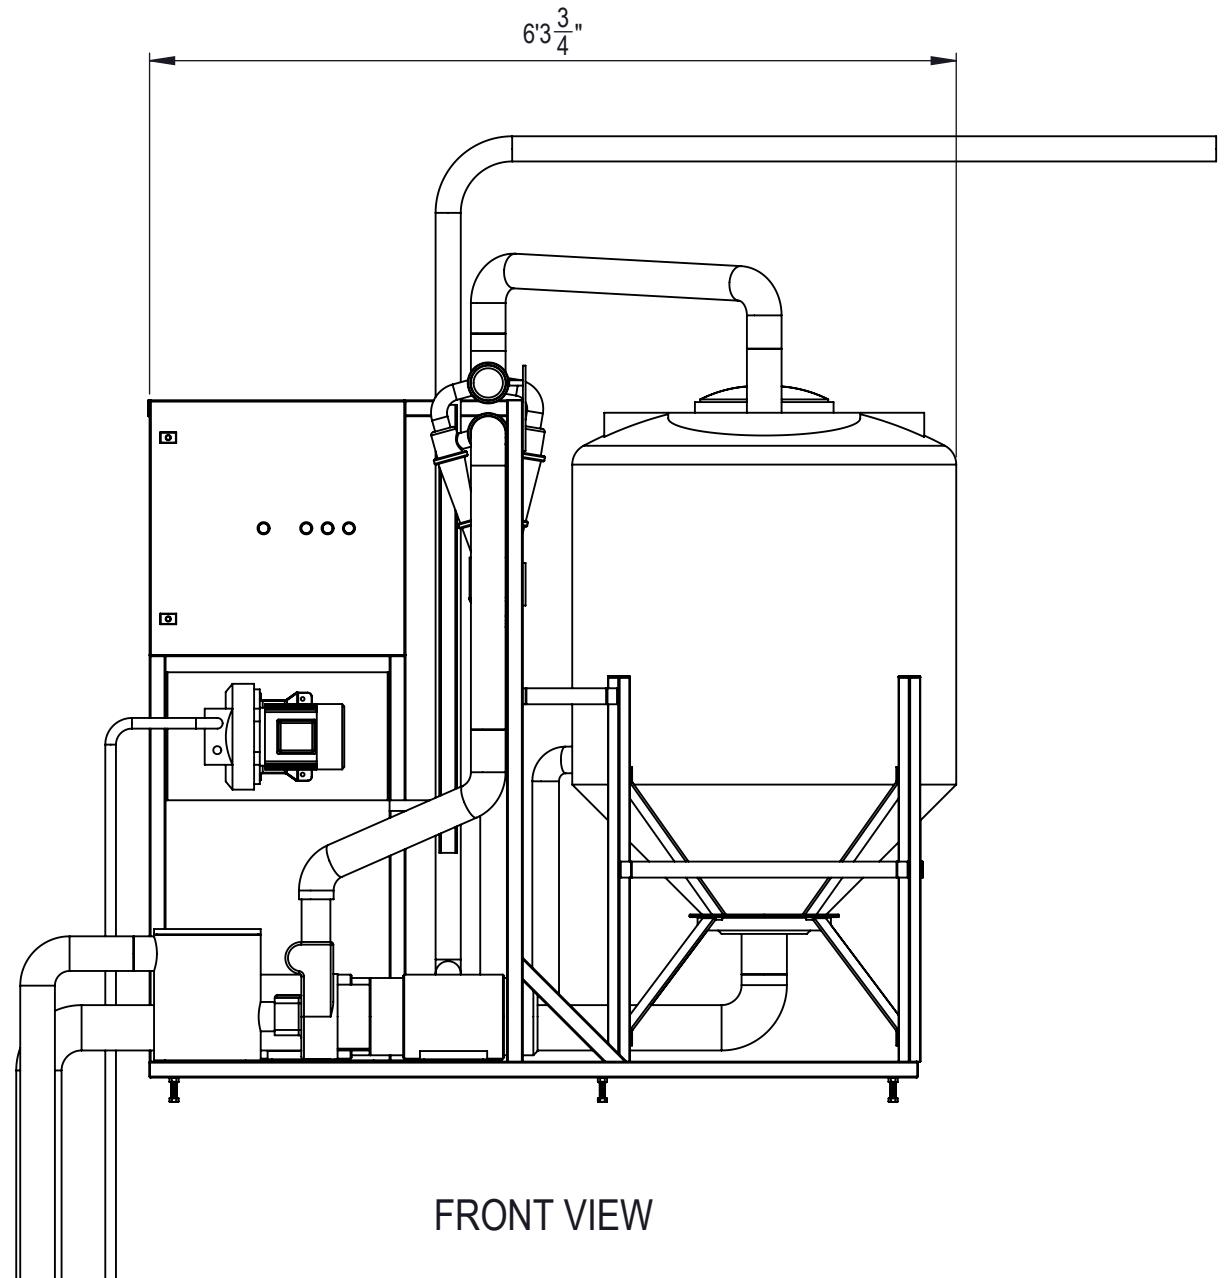

PIPING IS NOT DIMENSIONED DUE ROUTING  
VARIATIONS IN MECHANICAL INSTALLATION

PROPRIETARY AND CONFIDENTIAL  
THE INFORMATION CONTAINED IN THIS DRAWING  
IS THE SOLE PROPERTY OF  
AQUA BIO Technologies.  
ANY REPRODUCTION IN PART OR AS A WHOLE  
WITHOUT THE WRITTEN PERMISSION OF  
AQUA BIO Technologies  
IS PROHIBITED.

UNLESS OTHERWISE SPECIFIED:		
DRAWN	NAME	DATE
CHECKED	GM	5/1/2016
APPROVED		
CAD DESIGN BY:		
CADWorksPro		
Chicago, IL		
gilm@cadworkspro.com		
DO NOT SCALE DRAWING		

**AQUA BIO Technologies**

TITLE:  
Pro Limited System - 100-160 GPM

Mechanical Rack Overall Dimensions

SIZE	DWG. NO.	REV
B	PLS-005	
SCALE: 1:18	WEIGHT:	SHEET 5 OF 5

8 7 6 5 4 3 2 1

D

C

B

A

1